


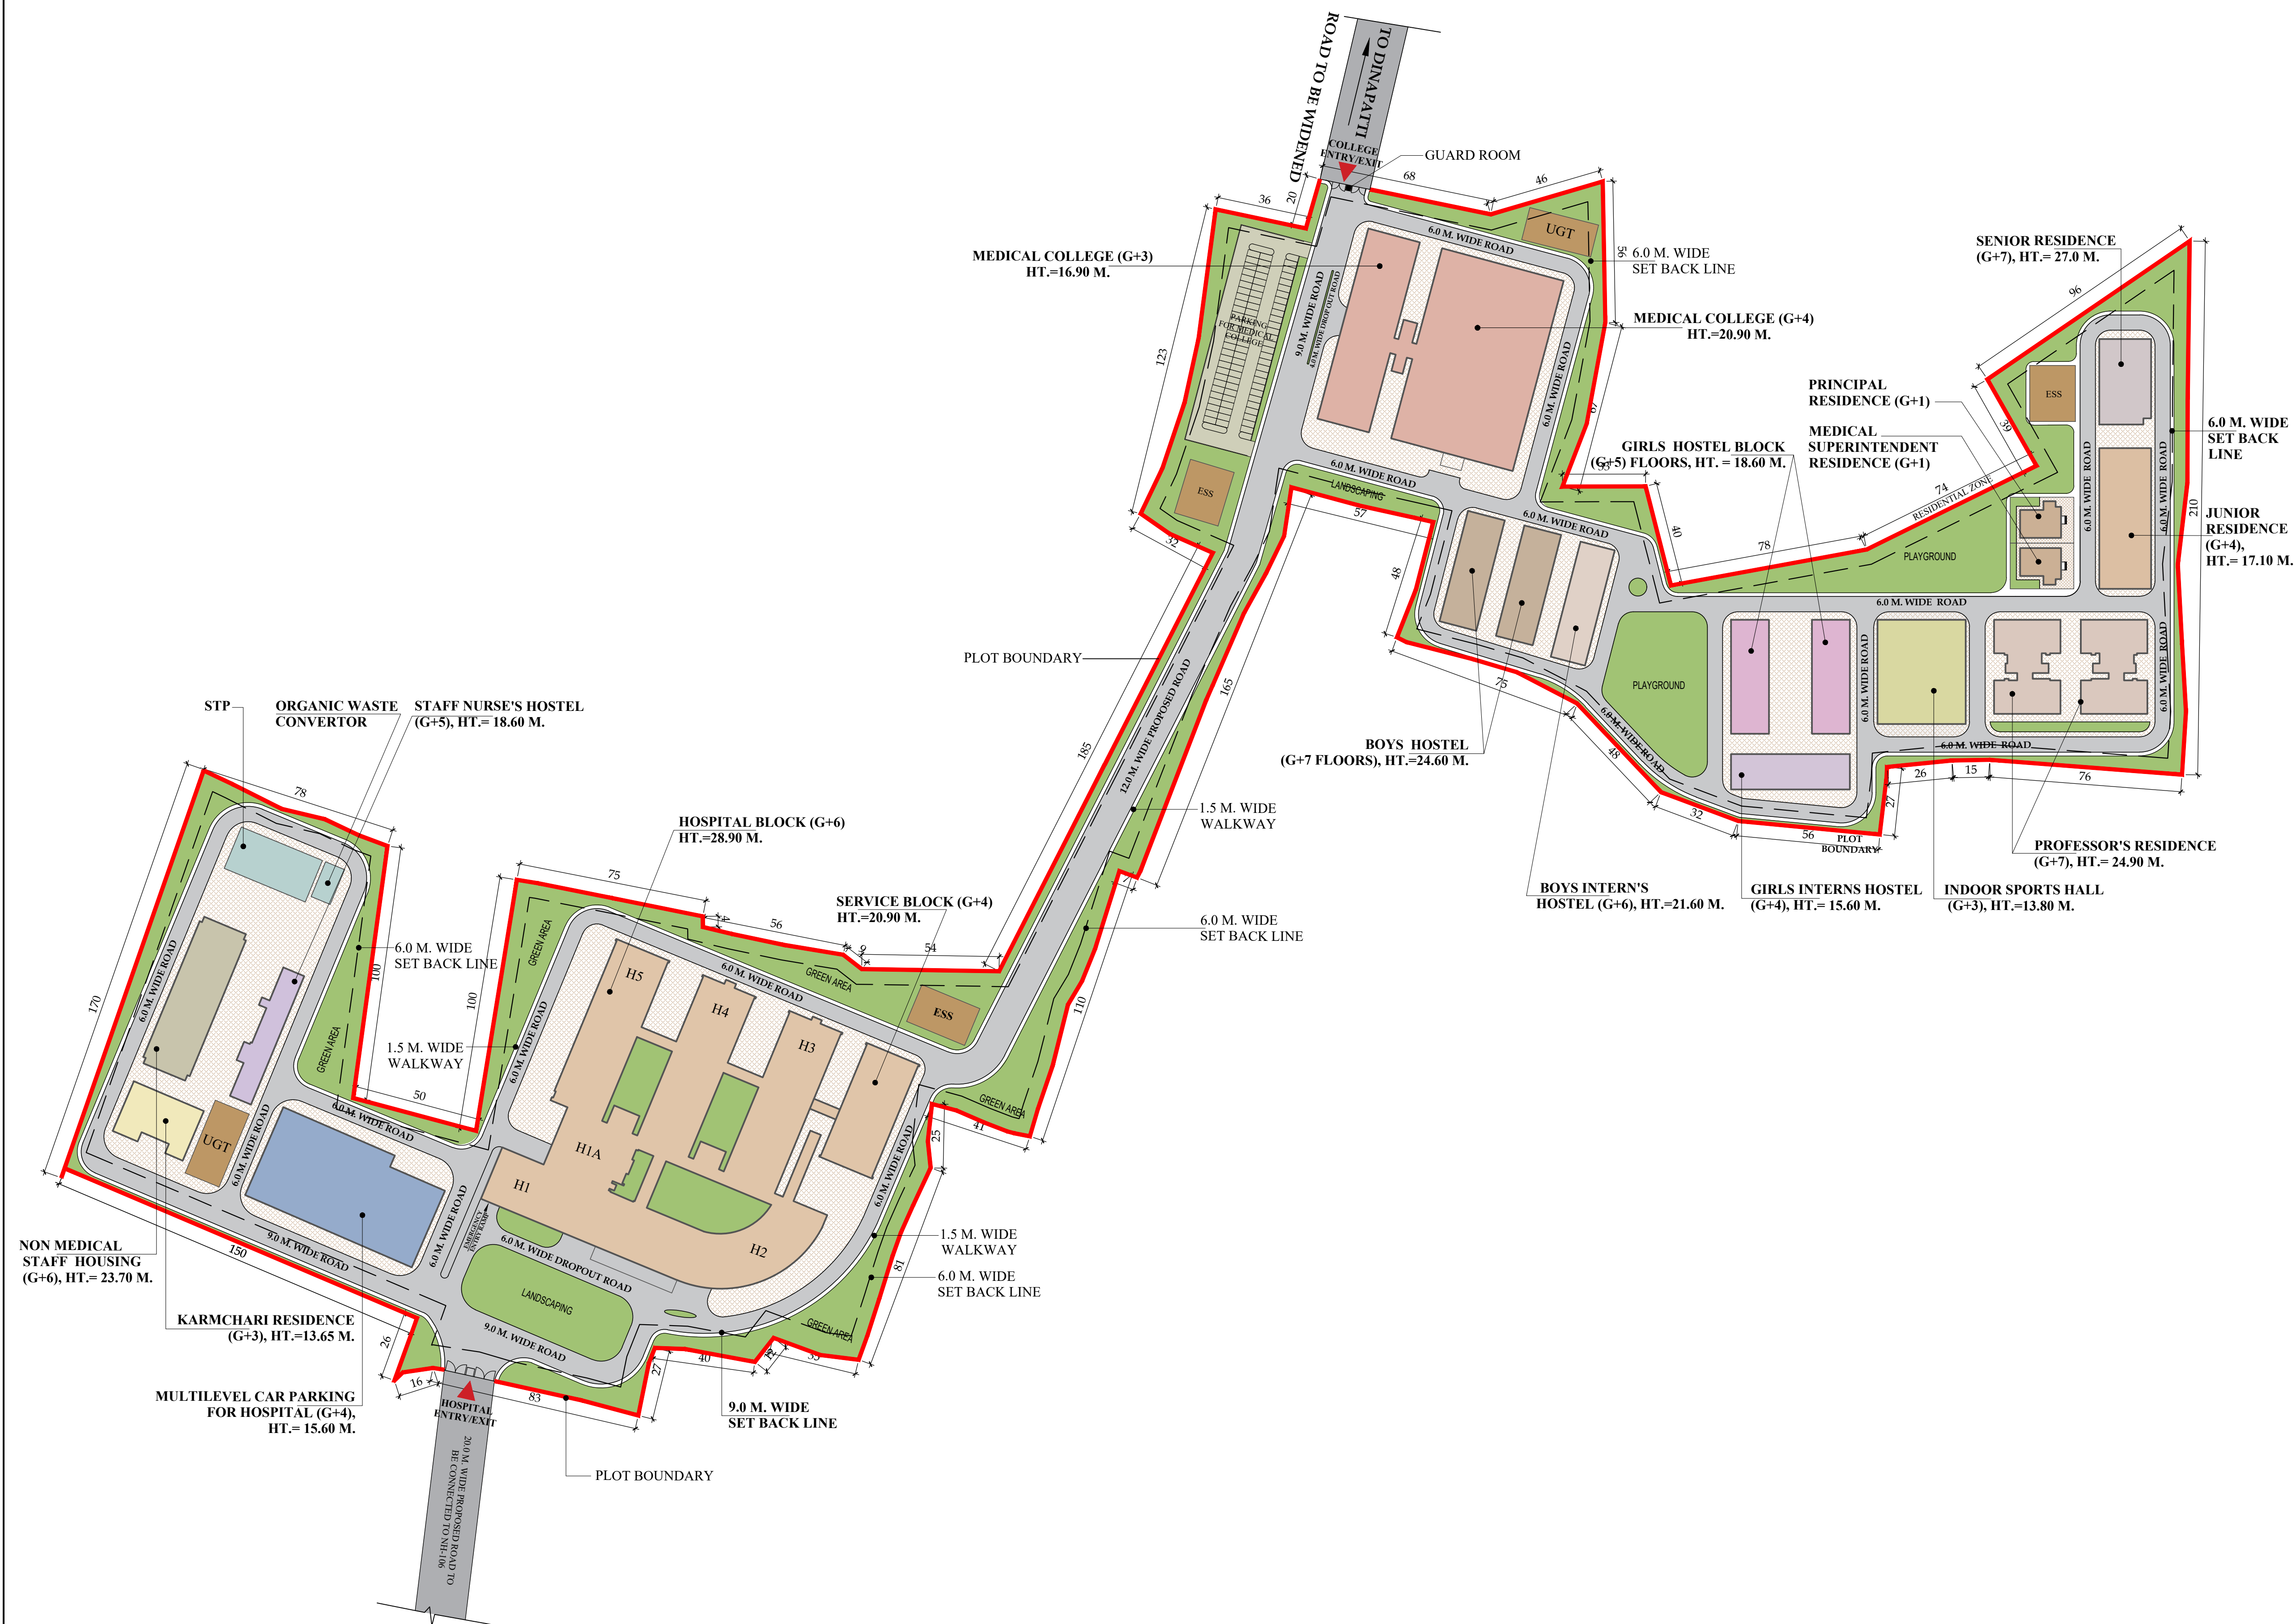

- GENERAL NOTES:
1. THIS DRAWING IS THE PROPERTY OF EDMAC CONSULTING. ITS COPYRIGHT IS RESERVED WITH THEM. IT MUST NOT BE RETAINED, COPIED OR REPRODUCED IN ANY FORM WITHOUT THE WRITTEN CONSENT OF EDMAC CONSULTING.
 2. ALL DIMENSIONS ARE IN MILLIMETERS UNLESS OTHERWISE NOTED. DO NOT SCALE DRAWING. ONLY WRITTEN DIMENSIONS ARE TO BE FOLLOWED.
 3. ALL DIMENSIONS TO BE VERIFIED BY THE CONTRACTOR AND DISCREPANCIES, IF ANY, REPORTED TO THE CONSULTANT BEFORE COMMENCING ANY WORK ON SITE.
 4. THIS DRAWING SHOULD BE READ IN CONJUNCTION WITH RELEVANT ARCHITECTURAL, STRUCTURAL AND SERVICES DRAWINGS, SPECIFICATIONS AND DETAILS.
 5. ALL LVL. ±0 CORRESPONDS TO LEVEL MENTIONED IN SITE PLAN AND OUTSIDE LANDSCAPE DRAWINGS.

BIHAR MEDICAL SERVICES & INFRASTRUCTURE CORPORATION LIMITED (GOVT. OF BIHAR UNDERTAKING)



Design Consultant :

EDMAC
ENGINEERING CONSULTANT

EDMAC Engineering Consultant (I) Pvt. Ltd.
G-1, L.G.F., South Extn-II, New Delhi - 49, Tel: 011-46078600, Fax: 011-46078666
E-mail : info@edmacconsulting.com, Web : www.edmacconsulting.com

FOR TENDER ONLY

PROPOSED CONSTRUCTION OF
LOHIA MEDICAL COLLEGE &
HOSPITAL
AT DISTRICT - SUPAUL (BIHAR)

SUPAUL (BIHAR)

MASTER PLAN
(ARCHITECTURE)

DRAWN BY QAMAR	CHECKED BY ANUPAM	APPROVED BY FAIZ	DATE MAR-23
JOB. NO. IND/B-	MP/AD.0		SCALE 1 : 1250
REV. NO.			SHEET NO. 01